


	ETC Source 4 Lustr+ 25/50
	ETC Source 4 Lustr+ 15/30
	Elation SIXPAR 200IP floorcan
	BriTeQ BT-THEATRE 100EC Mk2 LED Fresnel
	Lantern in house rig (focus is fixed)
	BriTeQ COB Blinder
	Fixture Number DMX Address

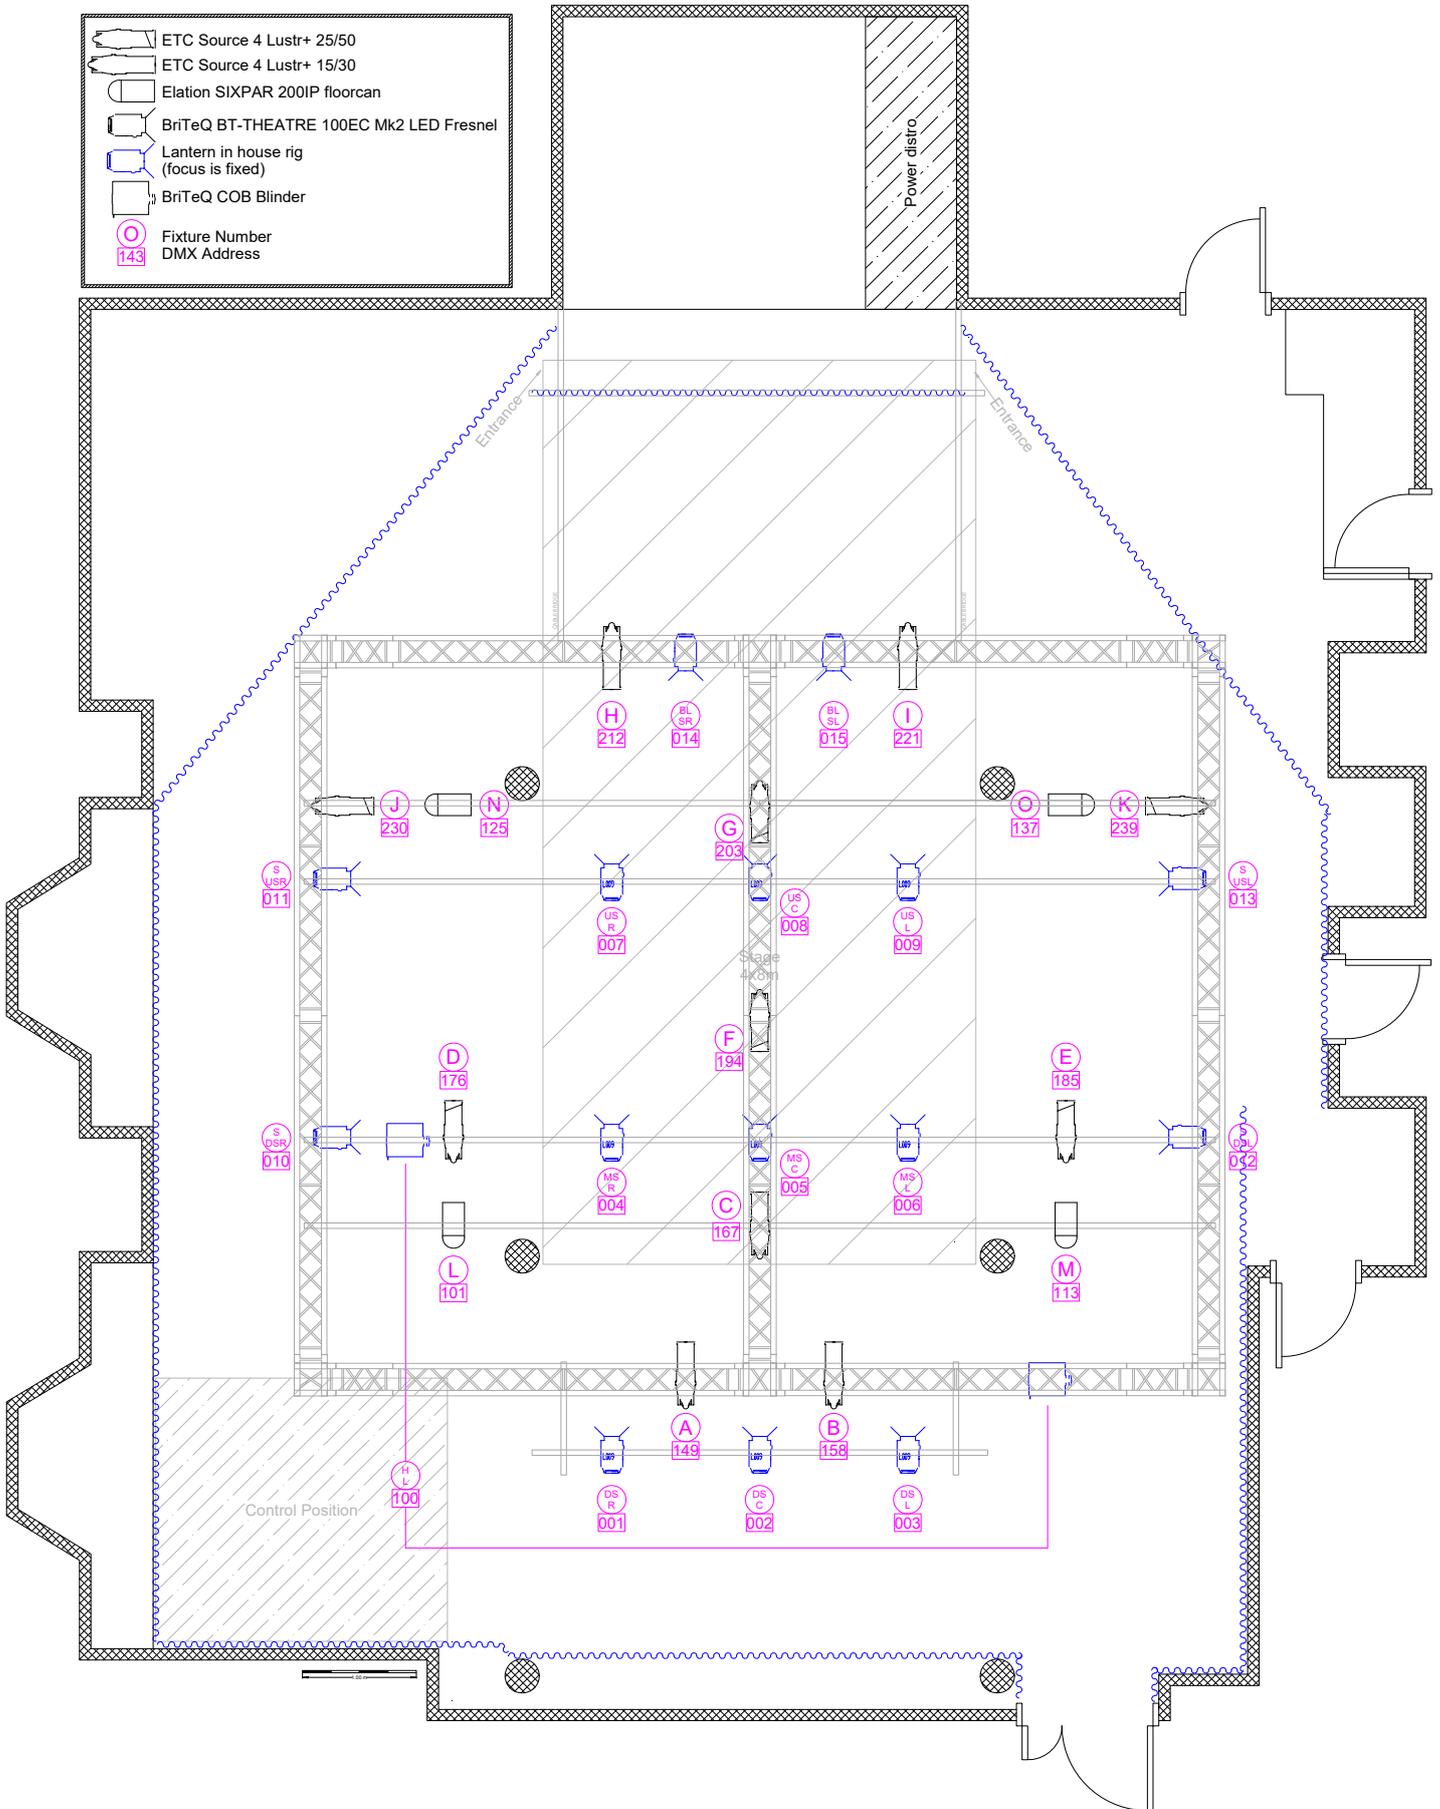

VENUE				Venue 45	
TITLE				LIGHTING Plan	
SIZE	DWG CODE	DWG NO	REV		
A4		theSpaceUK-VP-01-18	26.1		
SCALE	15mm = 1m			SHEET	