


1.00 m

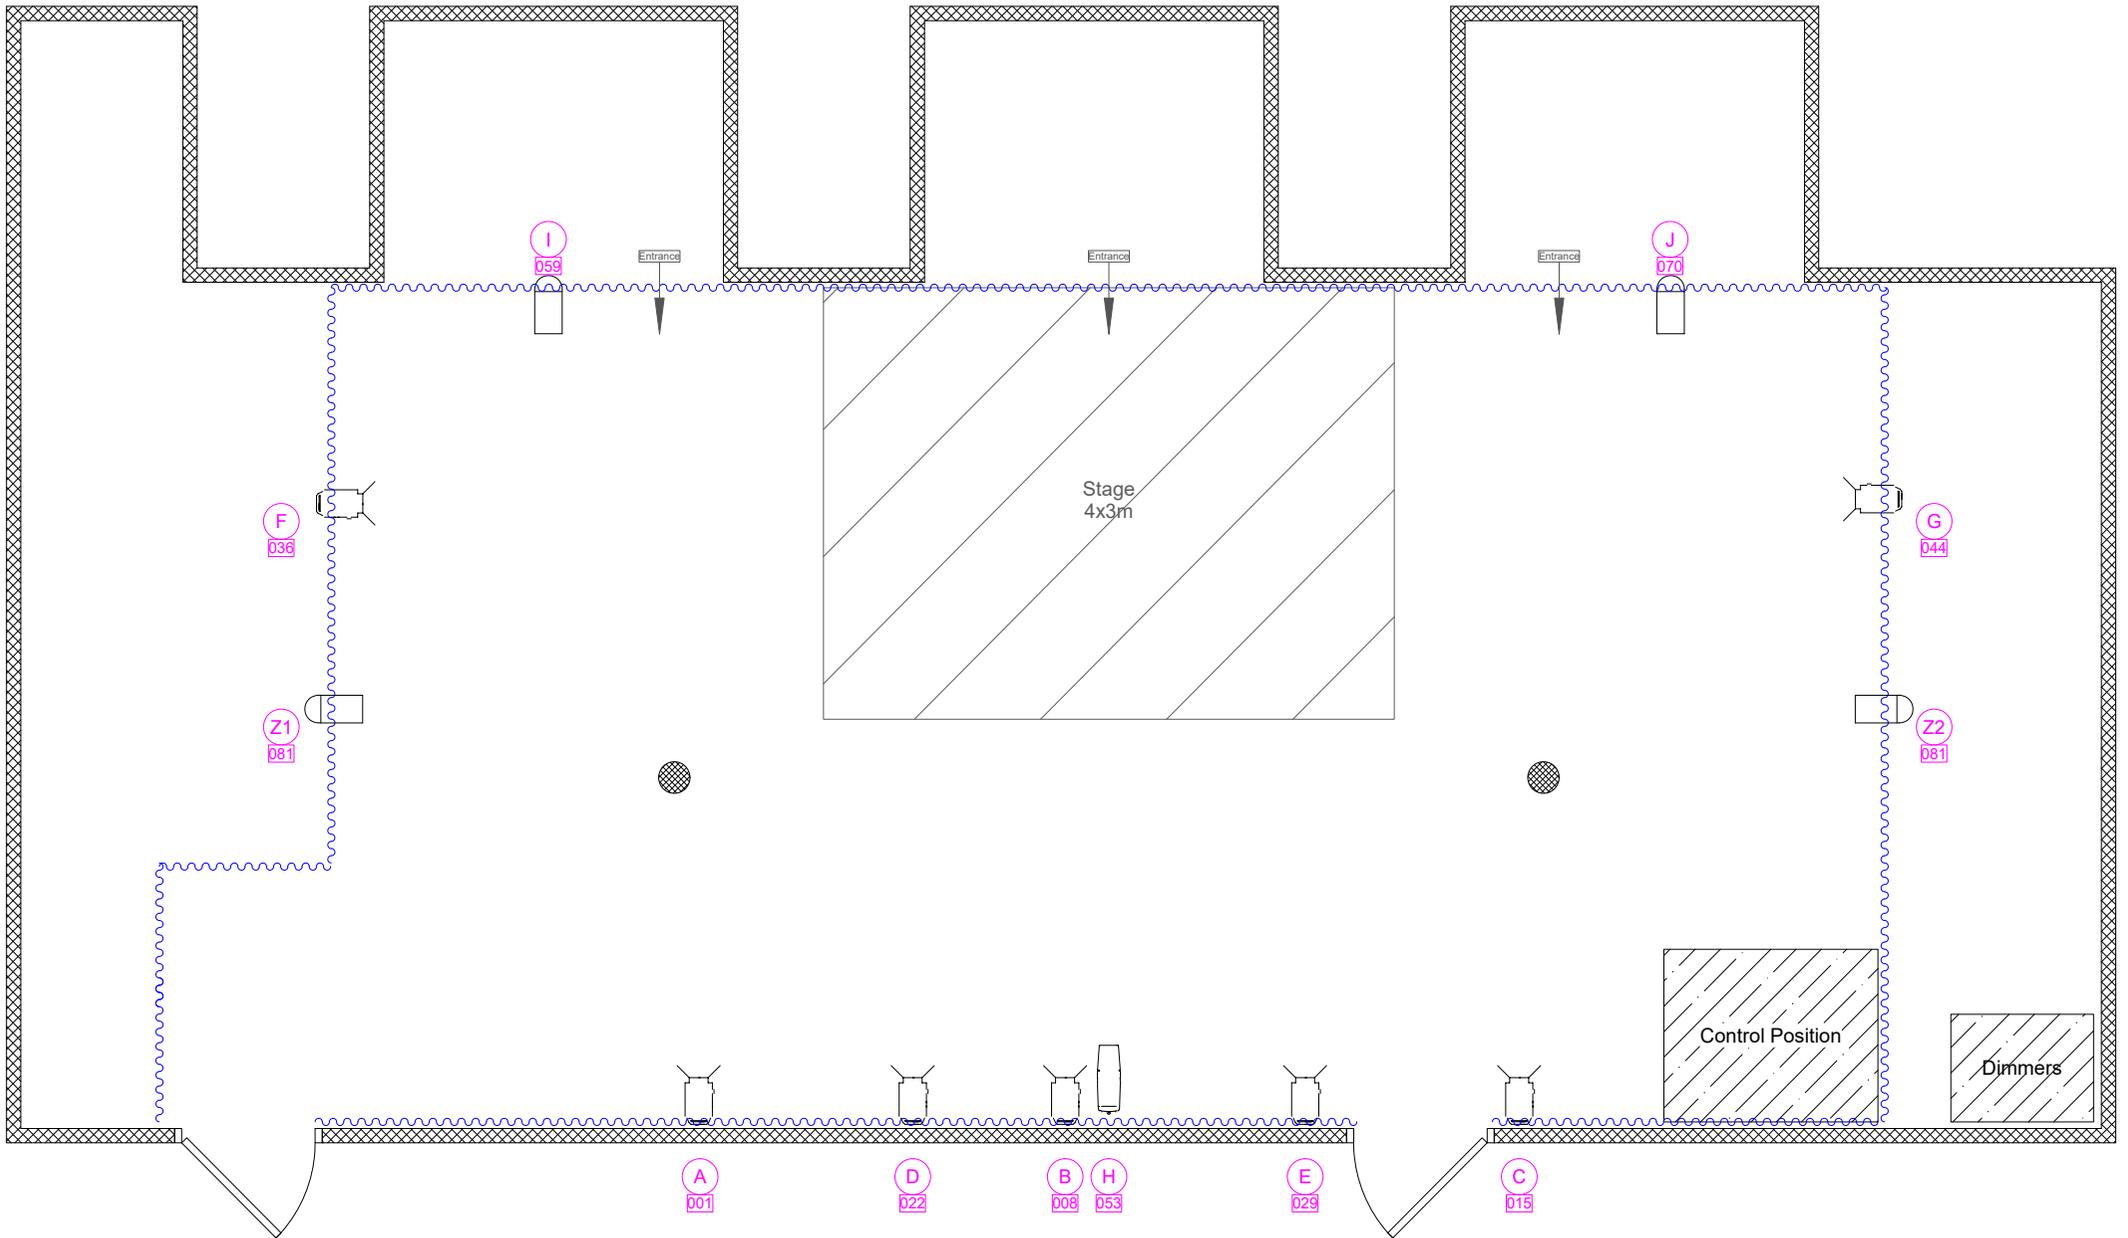

	Cameo Root Par 6 Mode: 11 ch P 3p
	Cameo F1 FC LED Fresnel RGBW Mode: RGB-CCT (7 ch) T 5p
	ColorSource Junior LED Profile 25-50 Mode: DIR (6 ch) P 5p
	Fixture Number
	DMX Address

VENUE		theSpace Triplex	
TITLE		Studio Theatre LIGHTING Plan	
SIZE	CAGE CODE	DWG NO	REV
A4		theSpaceUK-VP-18-18	26.1
SCALE		SHEET	