


	Robe Perfect Mode 1 - Standard 10 bk (14ch) P 5p
	LED Profile Mode: Let's say, 2ch P 3p
	Elumen8 LED Fresnel Mode: 1ch F 5p
	PixelLine Mode DMX RES=3ch (3ch) 16A 5p
	Fixture Number DMX Address

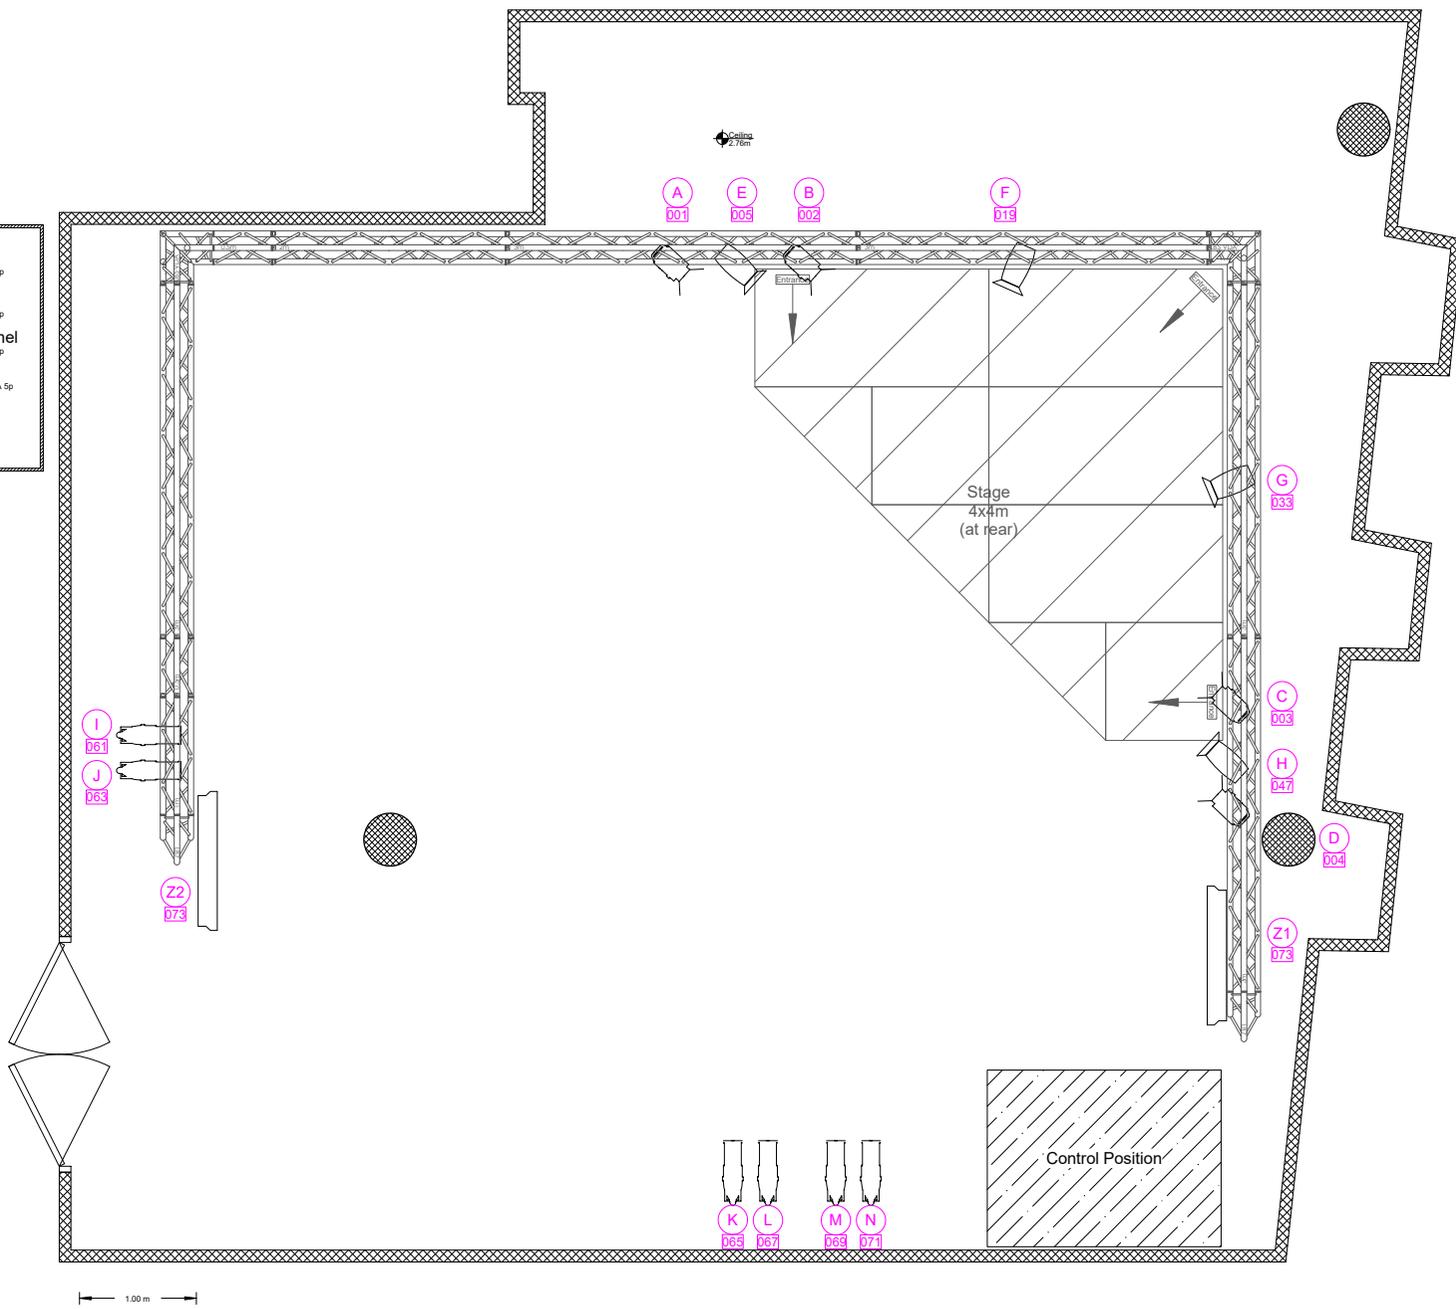

1.00 m

VENUE theSpace @ Surgeons' Hall			
TITLE Theatre 1 LIGHTING Plan			
SIZE A4	CAGE CODE	DWG NO theSpaceUK-VP-06-18	REV 26.1
SCALE	SHEET		